

NOTE: PIT SYMBOLS ARE NOT 1:1 SCALE



 **OPTICOMM**
Networks

TABLE 364F TABLE 329F LE MBLY (LIA)	Drawing Identification			
	RIGB-0002			
IN --- CONDUIT LENGTH --- CONDUIT LENGTH	STATE: QLO	REGION: GYMPIE		
DRAWING TITLE:				
RIGBY ESTATE STAGE 2 CIVIL / FTTH NETWORK KEY PLAN				
PROJECT ID: N/A		ELEC PROJ ID: N/A		
EIGNATION EIGNATION	SCALE NTS	SHEET No. KP	OF 5	REV. 2

OPTICOMM PROJECT MANAGER : SEAN MULDOON		-					
CONTACT NUMBER : 0436 612 950		-					
EMAIL : SMULDOON@OPTICOMM.COM.AU		-					
 WARNING BEWARE OF UNDERGROUND SERVICES THE LOCATION OF UNDERGROUND CABLES ARE APPROXIMATE ONLY AND THEIR EXACT POSITION SHOULD BE CHECKED ON SITE. LOCATE ALL UNDERGROUND SERVICES AND CABLES BEFORE COMMENCEMENT OF WORK. DIAL 1100 BEFORE YOU DIG		-					
		-					
		2	20-10-2025	R.S.	CIVIL DESIGN AMENDED AS PER LATEST NBN CIVIL DESIGN	M.T.	N.V.
		1	25-08-2025	R.R.	CIVIL DESIGN ISSUED FOR CONSTRUCTION	M.T.	N.V.
		REV	DATE	DESIGN	DESCRIPTION	CHECKED	APPROVED

rawing Identification			
RIGB-0002			
STATE: QLD	REGION: GYMPIE		
DRAWING TITLE:			
RIGBY ESTATE			
STAGE 2			
CIVIL / FTTH NETWORK			
KEY PLAN			
PROJECT ID:	N/A	ELEC PROJ ID:	N/A
SCALE	SHEET No.		REV.
1:1	1	OF 5	2



OPTICOMM
Networks

Built on better™



OPTICOMM DISCLAIMER

THIS DOCUMENT HAS BEEN PREPARED SOLELY FOR THE USE OF OPTICOMM LIMITED.

FOR USE IN MAINTAINING OPTICOMM FACILITIES.

IT HAS NOT BEEN CREATED FOR ANY OTHER USE.

IT SHOULD NOT BE SCALED TO LOCATE OPTICOMM ASSETS.

IT SHALL NOT BE SCALED. DUE TO THE SCHEMATIC NATURE OF THIS DRAWING.

EXACT LOCATION OF ALL PLANT SHALL BE CO-ORDINATED AND VERIFIED ON SITE.

OPTICOMM PROJECT MANAGER : SEAN MULDOON

CONTACT NUMBER : 0436 612 950

EMAIL : SMULDOON@OPTICOMM.COM.AU




WARNING
BEWARE OF UNDERGROUND SERVICES
THE LOCATION OF UNDERGROUND CABLES ARE APPROXIMATE ONLY AND THEIR EXACT POSITION SHOULD BE CHECKED ON SITE. LOCATE ALL UNDERGROUND SERVICES AND CABLES BEFORE COMMENCEMENT OF WORK.

-					
-					
-					
-					
-					
-					
2	20-10-2025	R.S.	CIVIL DESIGN AMENDED AS PER LATEST NBN CIVIL DESIGN	M.T.	N.V.
1	25-08-2025	R.R.	CIVIL DESIGN ISSUED FOR CONSTRUCTION	M.T.	N.V.
REV	DATE	DESIGN	DESCRIPTION	CHECKED	APPROVED

	P100	1 x 100mm ID Telecommunication Pipe		Electrical Kiosk/Transformer/Switchgear		FIBRE TRUNK CABLE 164P
	P100	1 x 100mm ID Telecommunication Pipe		Broadband Aggregation Node (BAN)		FIBRE TRUNK CABLE 72P
	P100	1 x 100mm ID Telecommunication Pipe		Fibre Access Node (FAN)		FIBRE TRUNK CABLE 24P
	P100	1 x 100mm ID Telecommunication Pipe		Headend Rack (KDF)		NAP TAIL CABLE
	P100	1 x 100mm ID Telecommunication Pipe		Fibre Joint Closure (FJC)		LEAD-IN ASSEMBLY (LIA)
	P100	1 x 100mm ID Telecommunication Pipe used as a Protective Sleeve				
	P100	1 x 100mm ID Telecommunication Pipe				
	P100	Minimum Pipe Bend Radius for 50mm and 100mm ID Telecommunication Pipe = 500mm				
	P100	P1 Telecommunication PH				
	P100	P2 Telecommunication PH				
	P100	P3 Telecommunication PH				
	P100	P58 Telecommunication PH				

Drawing Identification			
RIGB-0002			
STATE: QLD	REGION: GYMPIE		
DRAWING TITLE:			
RIGBY ESTATE			
STAGE 2			
CIVIL / FTTH NETWORK			
CONSTRUCTION PLAN			
PROJECT ID: N/A	ELEC PROJ ID: N/A		
SCALE NTS	SHEET No. 1	OF 5	REV. 2

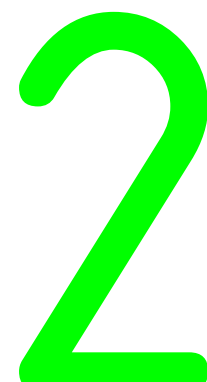

STAGE 2

Drawing Identification			
RIGB-0002			
STATE: OLD		REGION: GYMPIE	
DRAWING TITLE:			
RIGBY ESTATE			
STAGE 2			
CIVIL / FTTH NETWORK			
CONSTRUCTION PLAN			
PROJECT ID: N/A		ELEC PROJ ID: N/A	
SCALE N.T.S.	SHEET No. 2	OF 5	REV. 2

The site plan illustrates a proposed road network within a defined area. Key features include:

- Proposed Roads:** SPARKS CLOSE and HAACK COURT are labeled in green text along their respective alignments.
- Stationing:** Numerous points along the roads are marked with stationing, such as P50 5.0, P50 80.0, P50 86.0, P50 87.0, P50 88.0, P50 481.0,

Drawing Identification			
RIGB-0002			
STATE: OLD	REGION: GYMPIE		
DRAWING TITLE:			
RIGBY ESTATE			
STAGE 2			
CIVIL / FTTH NETWORK			
CONSTRUCTION PLAN			
PROJECT ID: N/A	ELEC PROJ ID: N/A		
SCALE N/Ts	SHEET No.	OF 5	REV. 2

4



Copyright (c) 2011 Opticomm Co Pty. Ltd
Copyright of this material resides with Opticomm Co Pty. Ltd. Apart from any fair dealing for the purposes of private study, research, criticism or review, as permitted under the Copyright Act 1968, no part may be reproduced or reused for any purposes whatever without prior written permission of the owner.



OPTICOMM DISCLAIMER
THIS DOCUMENT HAS BEEN PREPARED SOLELY FOR THE USE OF OPTICOMM LIMITED.
FOR USE IN MAINTAINING OPTICOMM FACILITIES.
IT HAS NOT BEEN CREATED FOR ANY OTHER USE.
IT SHOULD NOT BE SCALED TO LOCATE OPTICOMM ASSETS.
THE SCHEMATIC NATURE OF THIS DRAWING.
EXACT LOCATION OF ALL PLANT SHALL BE CO-ORDINATED AND VERIFIED ON SITE.

OPTICOMM PROJECT MANAGER : SEAN MULDOON

CONTACT NUMBER : 0436 612 950

EMAIL : SMULDOON@OPTICOMM.COM.AU

WARNING
BEWARE OF UNDERGROUND SERVICES
THE LOCATION OF UNDERGROUND CABLES ARE APPROXIMATE ONLY AND THEIR EXACT POSITION SHOULD BE CHECKED ON SITE. LOCATE ALL UNDERGROUND SERVICES AND CABLES BEFORE COMMENCEMENT OF WORK.

REV	DATE	DESIGN	DESCRIPTION	CHECKED	APPROVED
2	20-10-2025	R.S.	CIVIL DESIGN AMENDED AS PER LATEST NBN CIVIL DESIGN	M.T.	N.V.
1	25-08-2025	R.R.	CIVIL DESIGN ISSUED FOR CONSTRUCTION	M.T.	N.V.

1 x 100mm (C) Telecommunication Pipe
2 x 100mm (C) Telecommunication Pipe
3 x 100mm (C) Telecommunication Pipe
4 x 100mm (C) Telecommunication Pipe
5 x 100mm (C) Telecommunication Pipe
2 x 50mm (C) Telecommunication Pipe
1 x 50mm (C) Telecommunication Pipe
50mm Telecommunication Pipe used as a Protective Sleeve

Minimum Pipe Bend Radius for 50mm and 100mm Telecommunication Pipe = 800mm

P3 P4 P5 P6 P7 P8 P9 P10 P11 P12 P13 P14 P15 P16 P17 P18 P19 P20

Single Driveway
Double Driveway


Electrical Risk/Transformer/Switchgear
Broadband Aggregation Node (BAN)
Fibre Access Node (FAN)
Headend Rack (HDR)
Fibre Joint Closure (FJC)
Fibre Distribution Hub (FDH)
Connectorised FDH
OFDC 1:8 Connectorised FDH
Network Access Port x4 (NAP)
Connectorised NAP 4 Port
OFDC Connectorised NAP 12 Port
BUD PON 1 - WITH SPLICING TRAYS
BUD PON 2 - NO SPLICING TRAYS
RDT - RAPID WALLBOX

FIBRE TRUNK CABLE 24F
FIBRE TRUNK CABLE 72F
FIBRE TRUNK CABLE 24F
NAP TAIL CABLE
LEAD-IN ASSEMBLY (LIA)

CONDUIT CONFIGURATION
CONDUIT SIZE
CONDUIT QUANTITY
CONDUIT LENGTH
CONDUIT SIZE
CONDUIT QUANTITY
CONDUIT LENGTH

NAP CONFIGURATION
NAP NAME
NAP DESIGNATION
FDH DESIGNATION

Drawing Identification			
RIGB-0002			
STATE: QLD	REGION: GYMPIE		
DRAWING TITLE: RIGBY ESTATE STAGE 2 CIVIL / FTTH NETWORK CONSTRUCTION PLAN			
PROJECT ID: N/A	ELEC PROJ ID: N/A		
SCALE: NTS	SHEET No. 4	OF 5	REV. 2

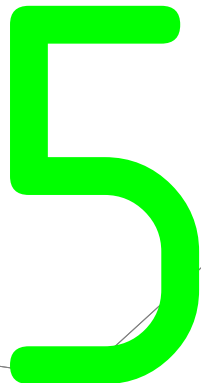

OPTICOMM
Networks

Built on better™




OPTICOMM DISCLAIMER
THIS DOCUMENT HAS BEEN PREPARED
SOLELY FOR THE USE OF OPTICOMM
LIMITED.
FOR USE IN MAINTAINING OPTICOMM
FACILITIES.
IT HAS NOT BEEN CREATED FOR ANY
OTHER USE.
IT SHOULD NOT BE SCALED TO
LOCATE OPTICOMM ASSETS.
IT SHALL NOT BE SCALED DUE TO
THE SCHEMATIC NATURE OF THIS
DRAWING.
EXACT LOCATION OF ALL PLANT
SHALL BE CO-ORDINATED AND
VERIFIED ON SITE.

OPTICOMM PROJECT MANAGER : SEAN MULDOON

CONTACT NUMBER : 0436 612 950

EMAIL : SMULDOON@OPTICOMM.COM.AU

-						
-						
-						
-						
-						
-						
2	20-10-2025	R.S.	CIVIL DESIGN AMENDED AS PER LATEST NBN CIVIL DESIGN	M.T.	N.V.	
1	25-08-2025	R.R.	CIVIL DESIGN ISSUED FOR CONSTRUCTION	M.T.	N.V.	
REV	DATE	DESIGN	DESCRIPTION	CHECKED	APPROVED	

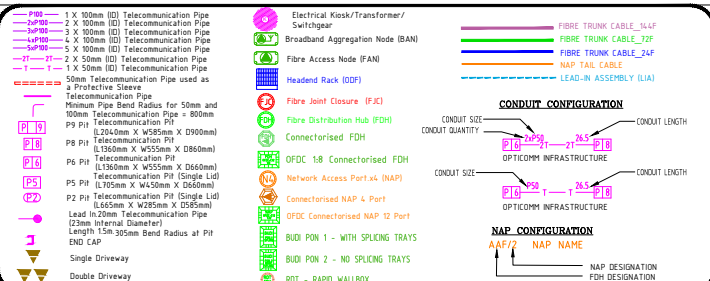

Drawing Identification		
RIGB-0002		
STATE: QLD	REGION: GYMPIE	
DRAWING TITLE:		
RIGBY ESTATE		
STAGE 2		
CIVIL / FTTH NETWORK		
CONSTRUCTION PLAN		
PROJECT ID: N/A	ELEC PROJ ID: N/A	
SCALE NITS	SHEET No. 5 OF 5	REV. 2